



Plot Date : 13 September 2022 13:01:56
File Name : X:\CAD\4534 ARGYLL SUBSTATIONS\01-WORKING\01_01-DRAWINGS\4534B_CRAIG MURRAIL\TOWN & COUNTRY PLANNING APPLICATION\4534B-DR-P-0015 P1 - ELECTRICAL LAYOUT ELEVATIONS 03

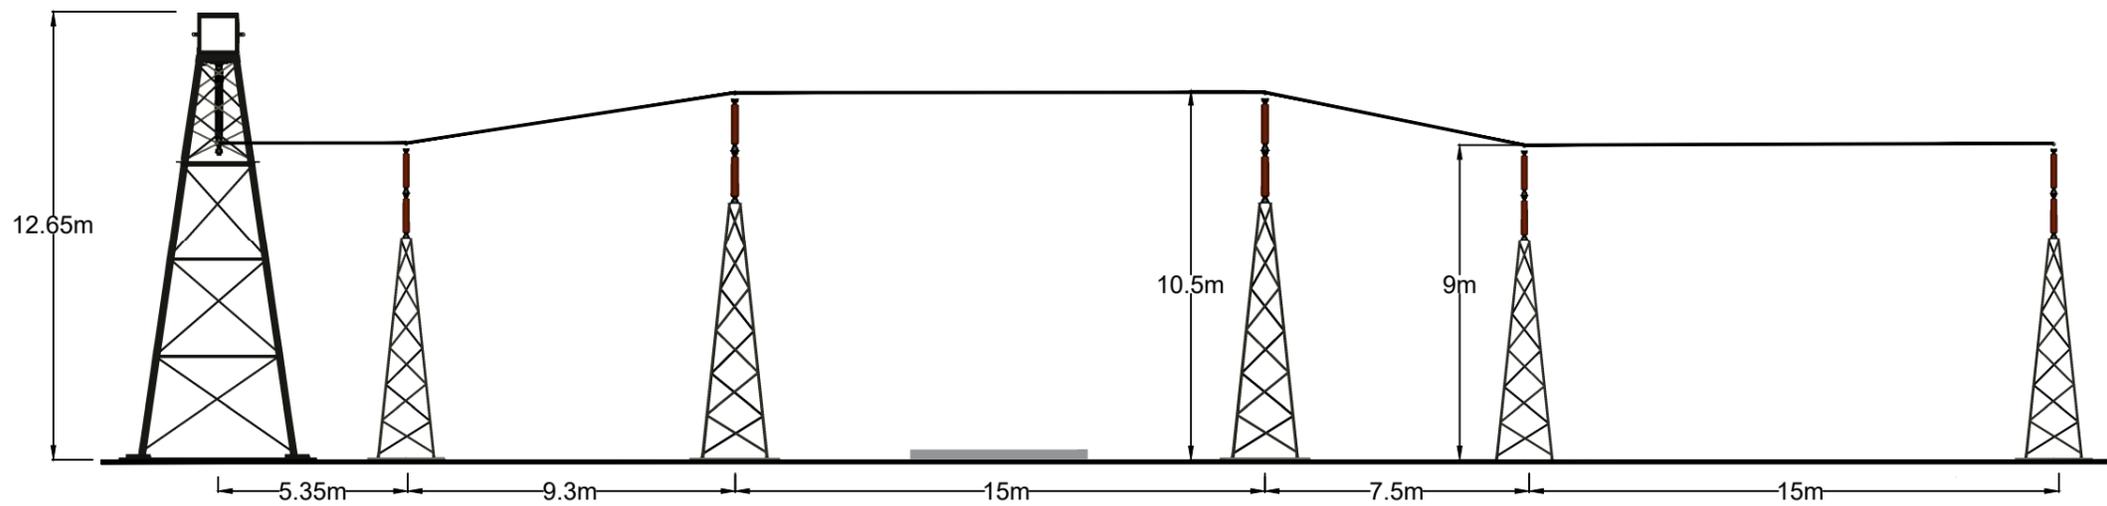

SIDE ELEVATION 'B9-B10'

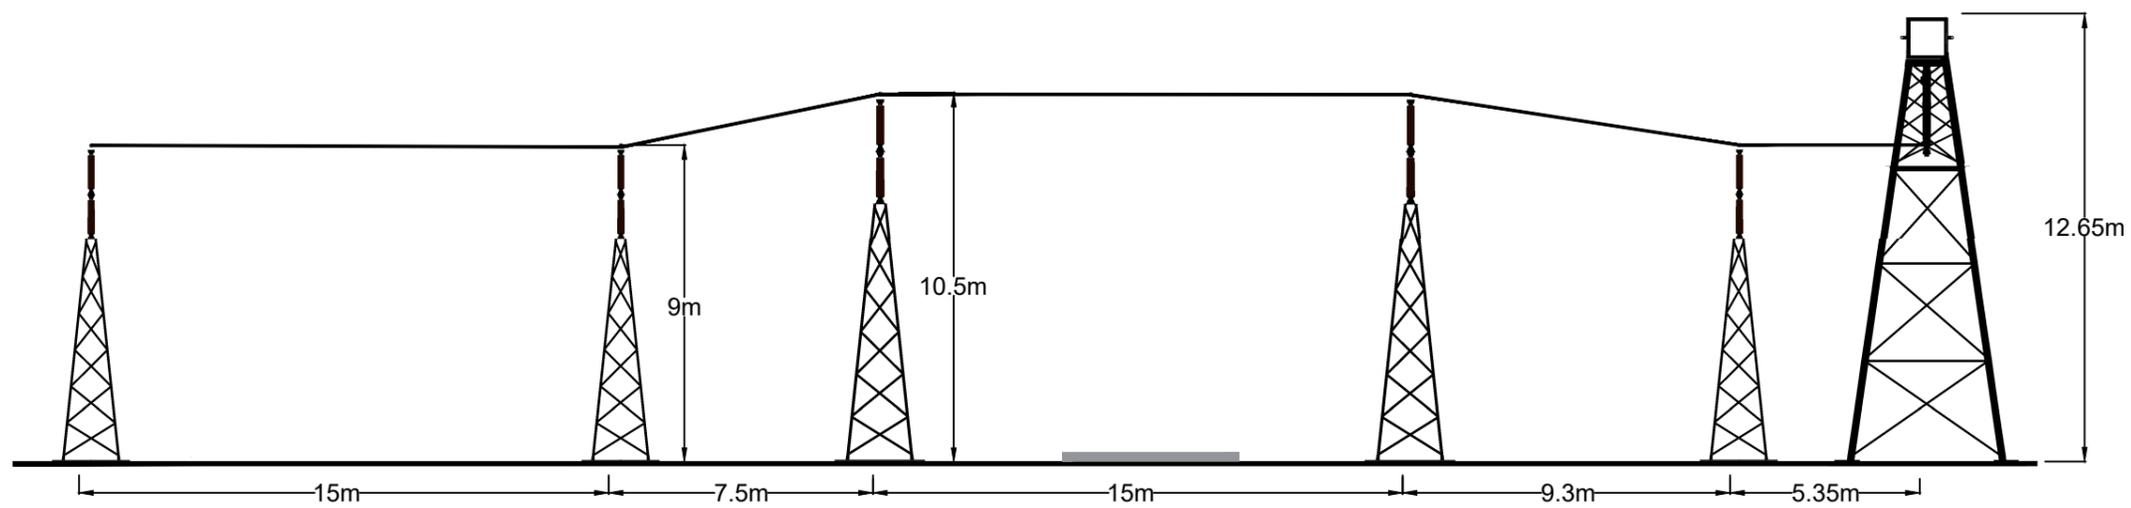

SIDE ELEVATION 'B11-B12'



SCALE 1:200

Note: See drawing 4534b-DR-P-0004 (Substation Compound Layout) for elevation locations.

Project Title CRAIG MURRAIL SUBSTATION		Drawing Title PLANNING FIGURE 006c ELECTRICAL LAYOUT ELEVATIONS 03		Purpose of issue PLANNING		THIS DOCUMENT HAS BEEN PREPARED IN ACCORDANCE WITH THE SCOPE OF ARCUS' APPOINTMENT WITH ITS CLIENT AND IS SUBJECT TO THE TERMS OF THAT APPOINTMENT. ARCUS ACCEPTS NO LIABILITY FOR ANY USE OF THIS DOCUMENT OTHER THAN BY ITS CLIENT AND ONLY FOR THE PURPOSES FOR WHICH IT WAS PREPARED AND PROVIDED		Arcus Consultancy Services 7th Floor 144 West George Street Glasgow, G2 2HG Tel: +44 (0)141 221 9997 Fax: +44 (0)141 221 5610 www.arcusconsulting.co.uk		
Client 		Designed -	Drawn RC	Checked RC	Approved DB					
		Scale @ A3 1:200		Drawing Number 4534b-DR-P-0015		Rev 1				